

REVISIONS	BY


HOLZMAN MOSS BOTTING ARCHITECTURE
 214 W. 28TH STREET, 17TH FLOOR
 NEW YORK, NEW YORK 10001
 HOLZMANMOSS.COM

ANTHONY L. LEPORE, ARCHITECT
 1401 EDGEWATER DRIVE
 ORLANDO, FLORIDA 32804
 LICENSE NUMBER: AR0004862
 TELEPHONE: (407) 425-4820

H.J. HIGH CONSTRUCTION CO.
 1015 W. AMELIA STREET
 ORLANDO, FLORIDA 32805
 TELEPHONE: (407) 422-8771
 FAX: (407) 844-4820

ADDITIONS + MODIFICATIONS
ENZIAN THEATER
 MATLAND, FLORIDA

DRAWN
CHECKED
DATE
1-28-2014
SCALE
JOB NO.
SHEET
P-2

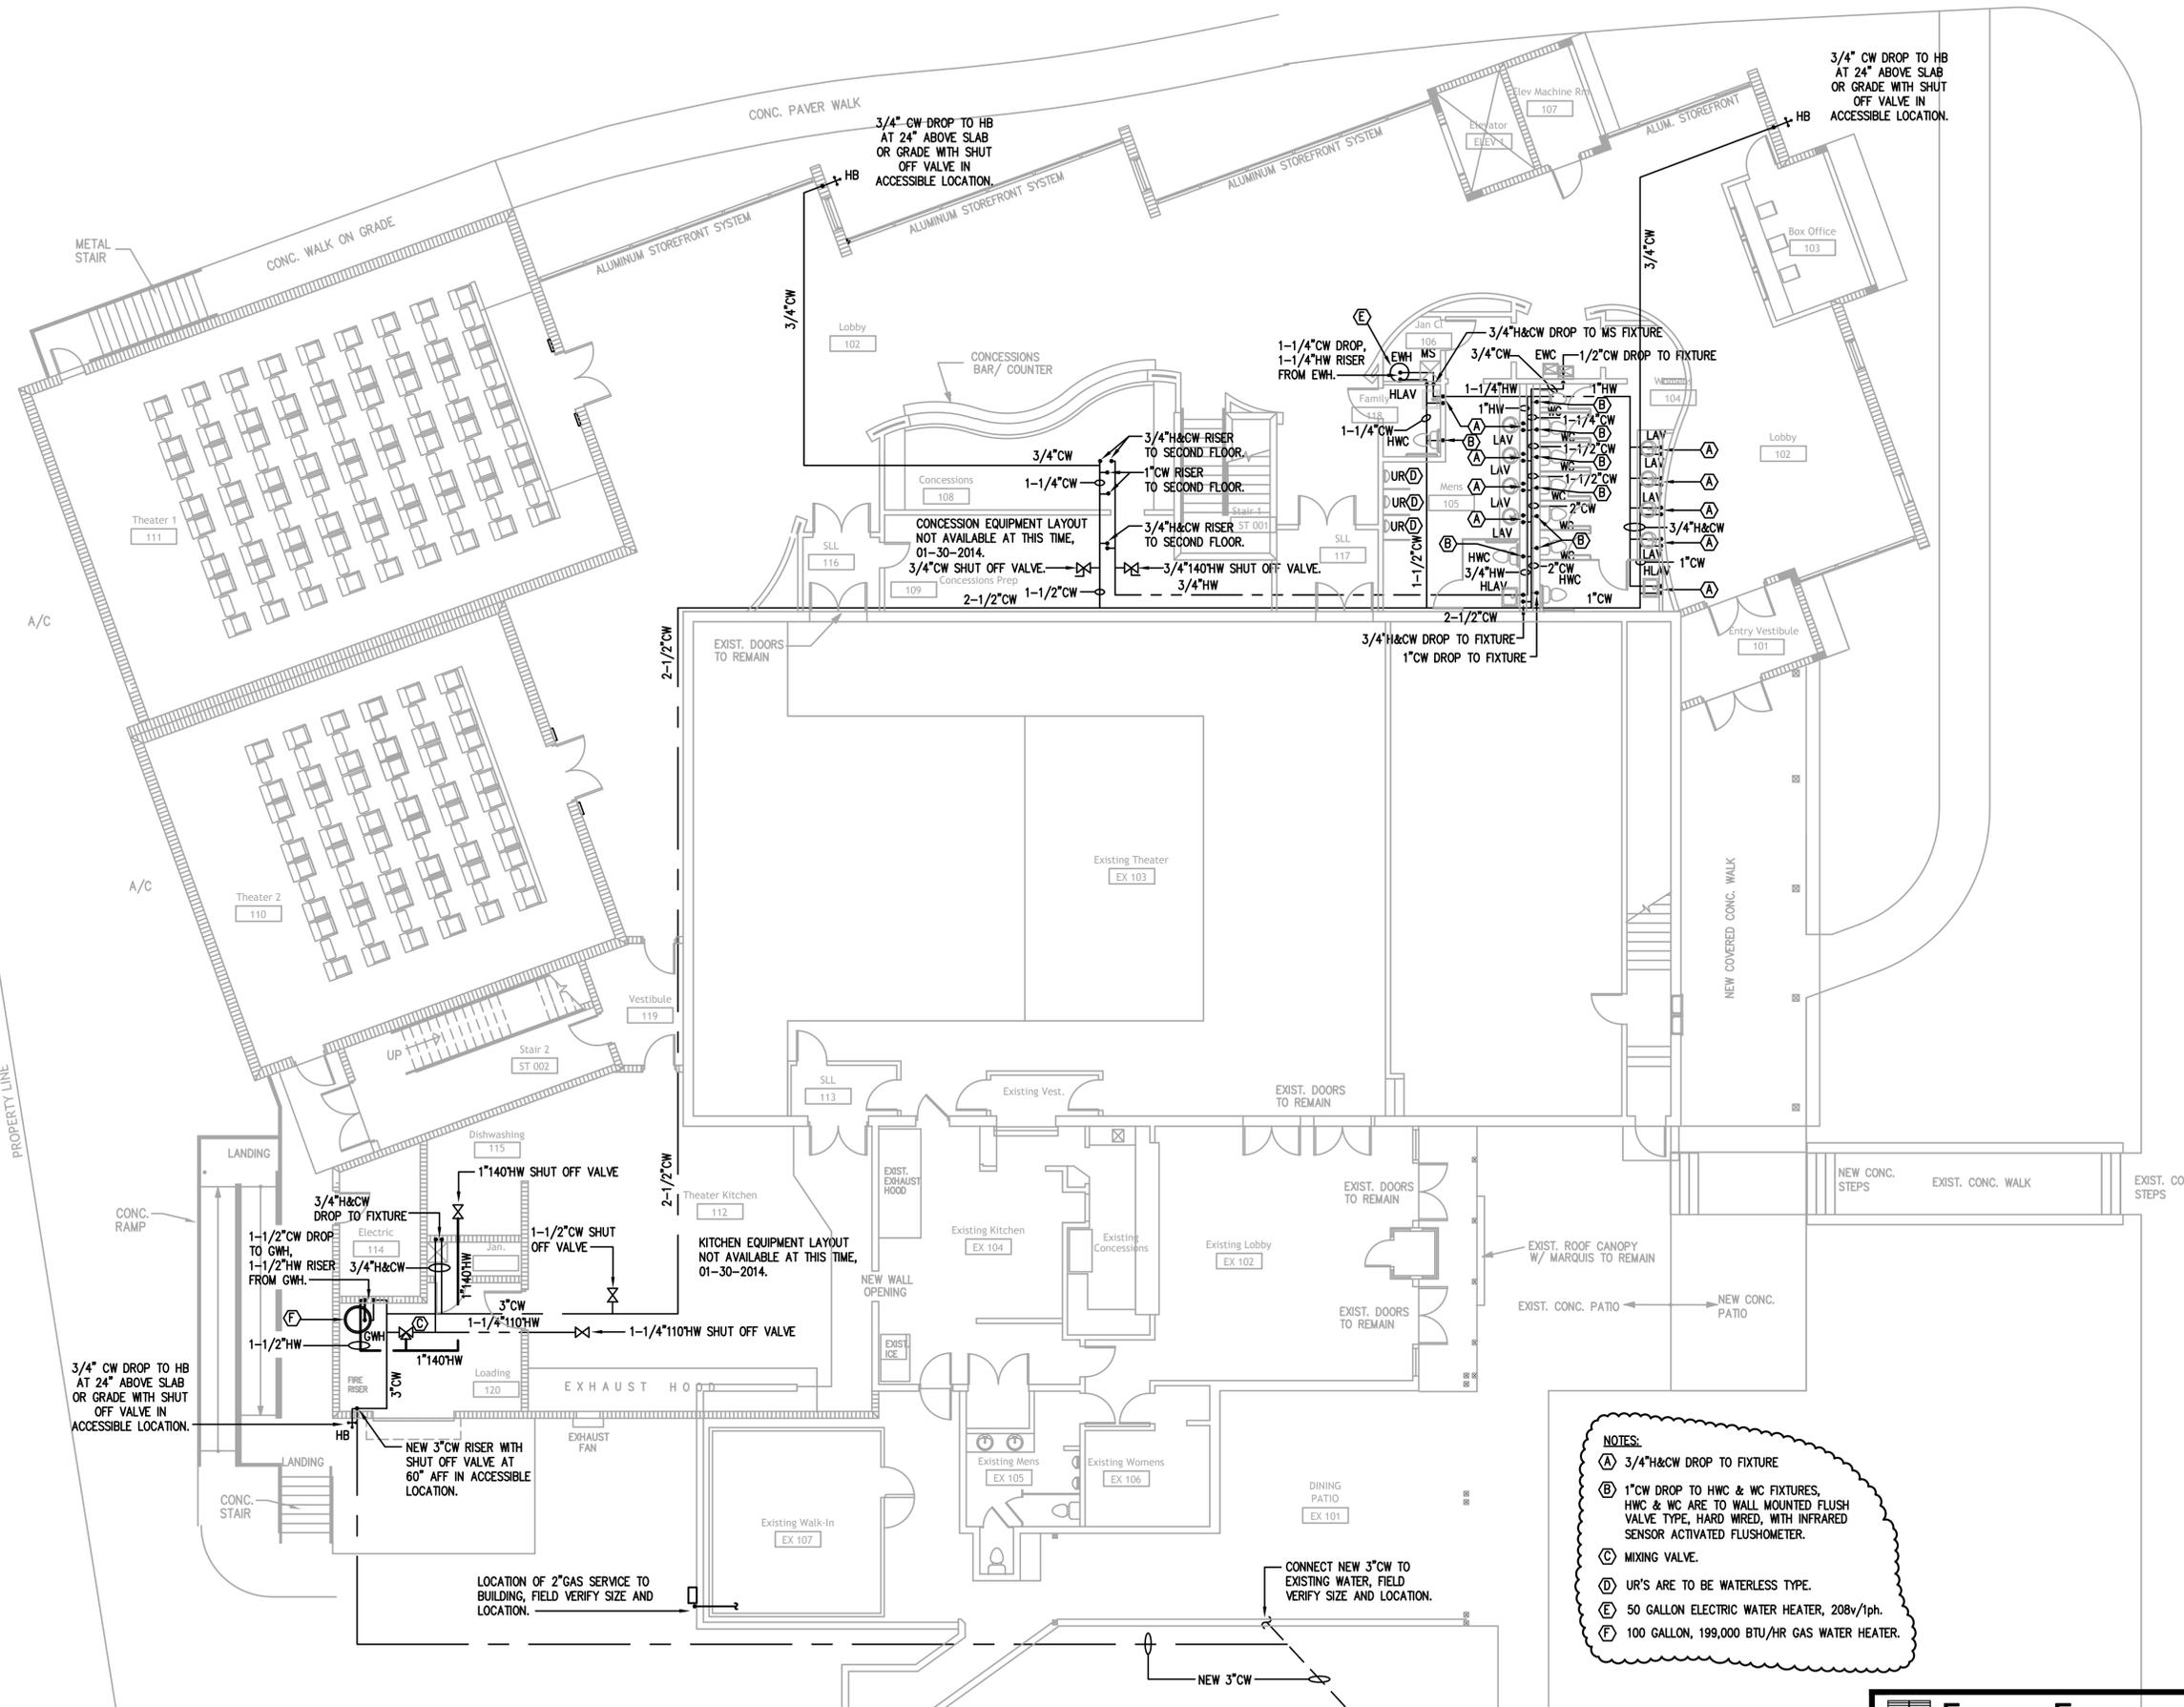

NOTES:
 (A) 3/4" H&CW DROP TO FIXTURE
 (B) 1" CW DROP TO HWC & WC FIXTURES, HWC & WC ARE TO WALL MOUNTED FLUSH VALVE TYPE, HARD WIRED, WITH INFRARED SENSOR ACTIVATED FLUSHMETER.
 (C) MIXING VALVE.
 (D) UR'S ARE TO BE WATERLESS TYPE.
 (E) 50 GALLON ELECTRIC WATER HEATER, 208v/1ph.
 (F) 100 GALLON, 199,000 BTU/HR GAS WATER HEATER.

FIRST FLOOR PLUMBING PLAN

SCALE: 1/8" = 1'-0"

EIERMANN ENGINEERING, INC.
 CONSULTING ENGINEERS
 1015 Webster Avenue, Orlando, Florida 32804
 TELEPHONE: (407) 298-8991 FAX: (407) 298-7420
 E-MAIL: EEBENG@AOL.COM
 © Copyright 2014 EIERMANN ENGINEERING, INC.
 FLORIDA EB #0006900 FLORIDA REG. #930781
 EEI JOB # 2013-135

KENNETH L. EIERMANN P.E.
 FLA. REG. #30761